
MBINED

INERBO

RD

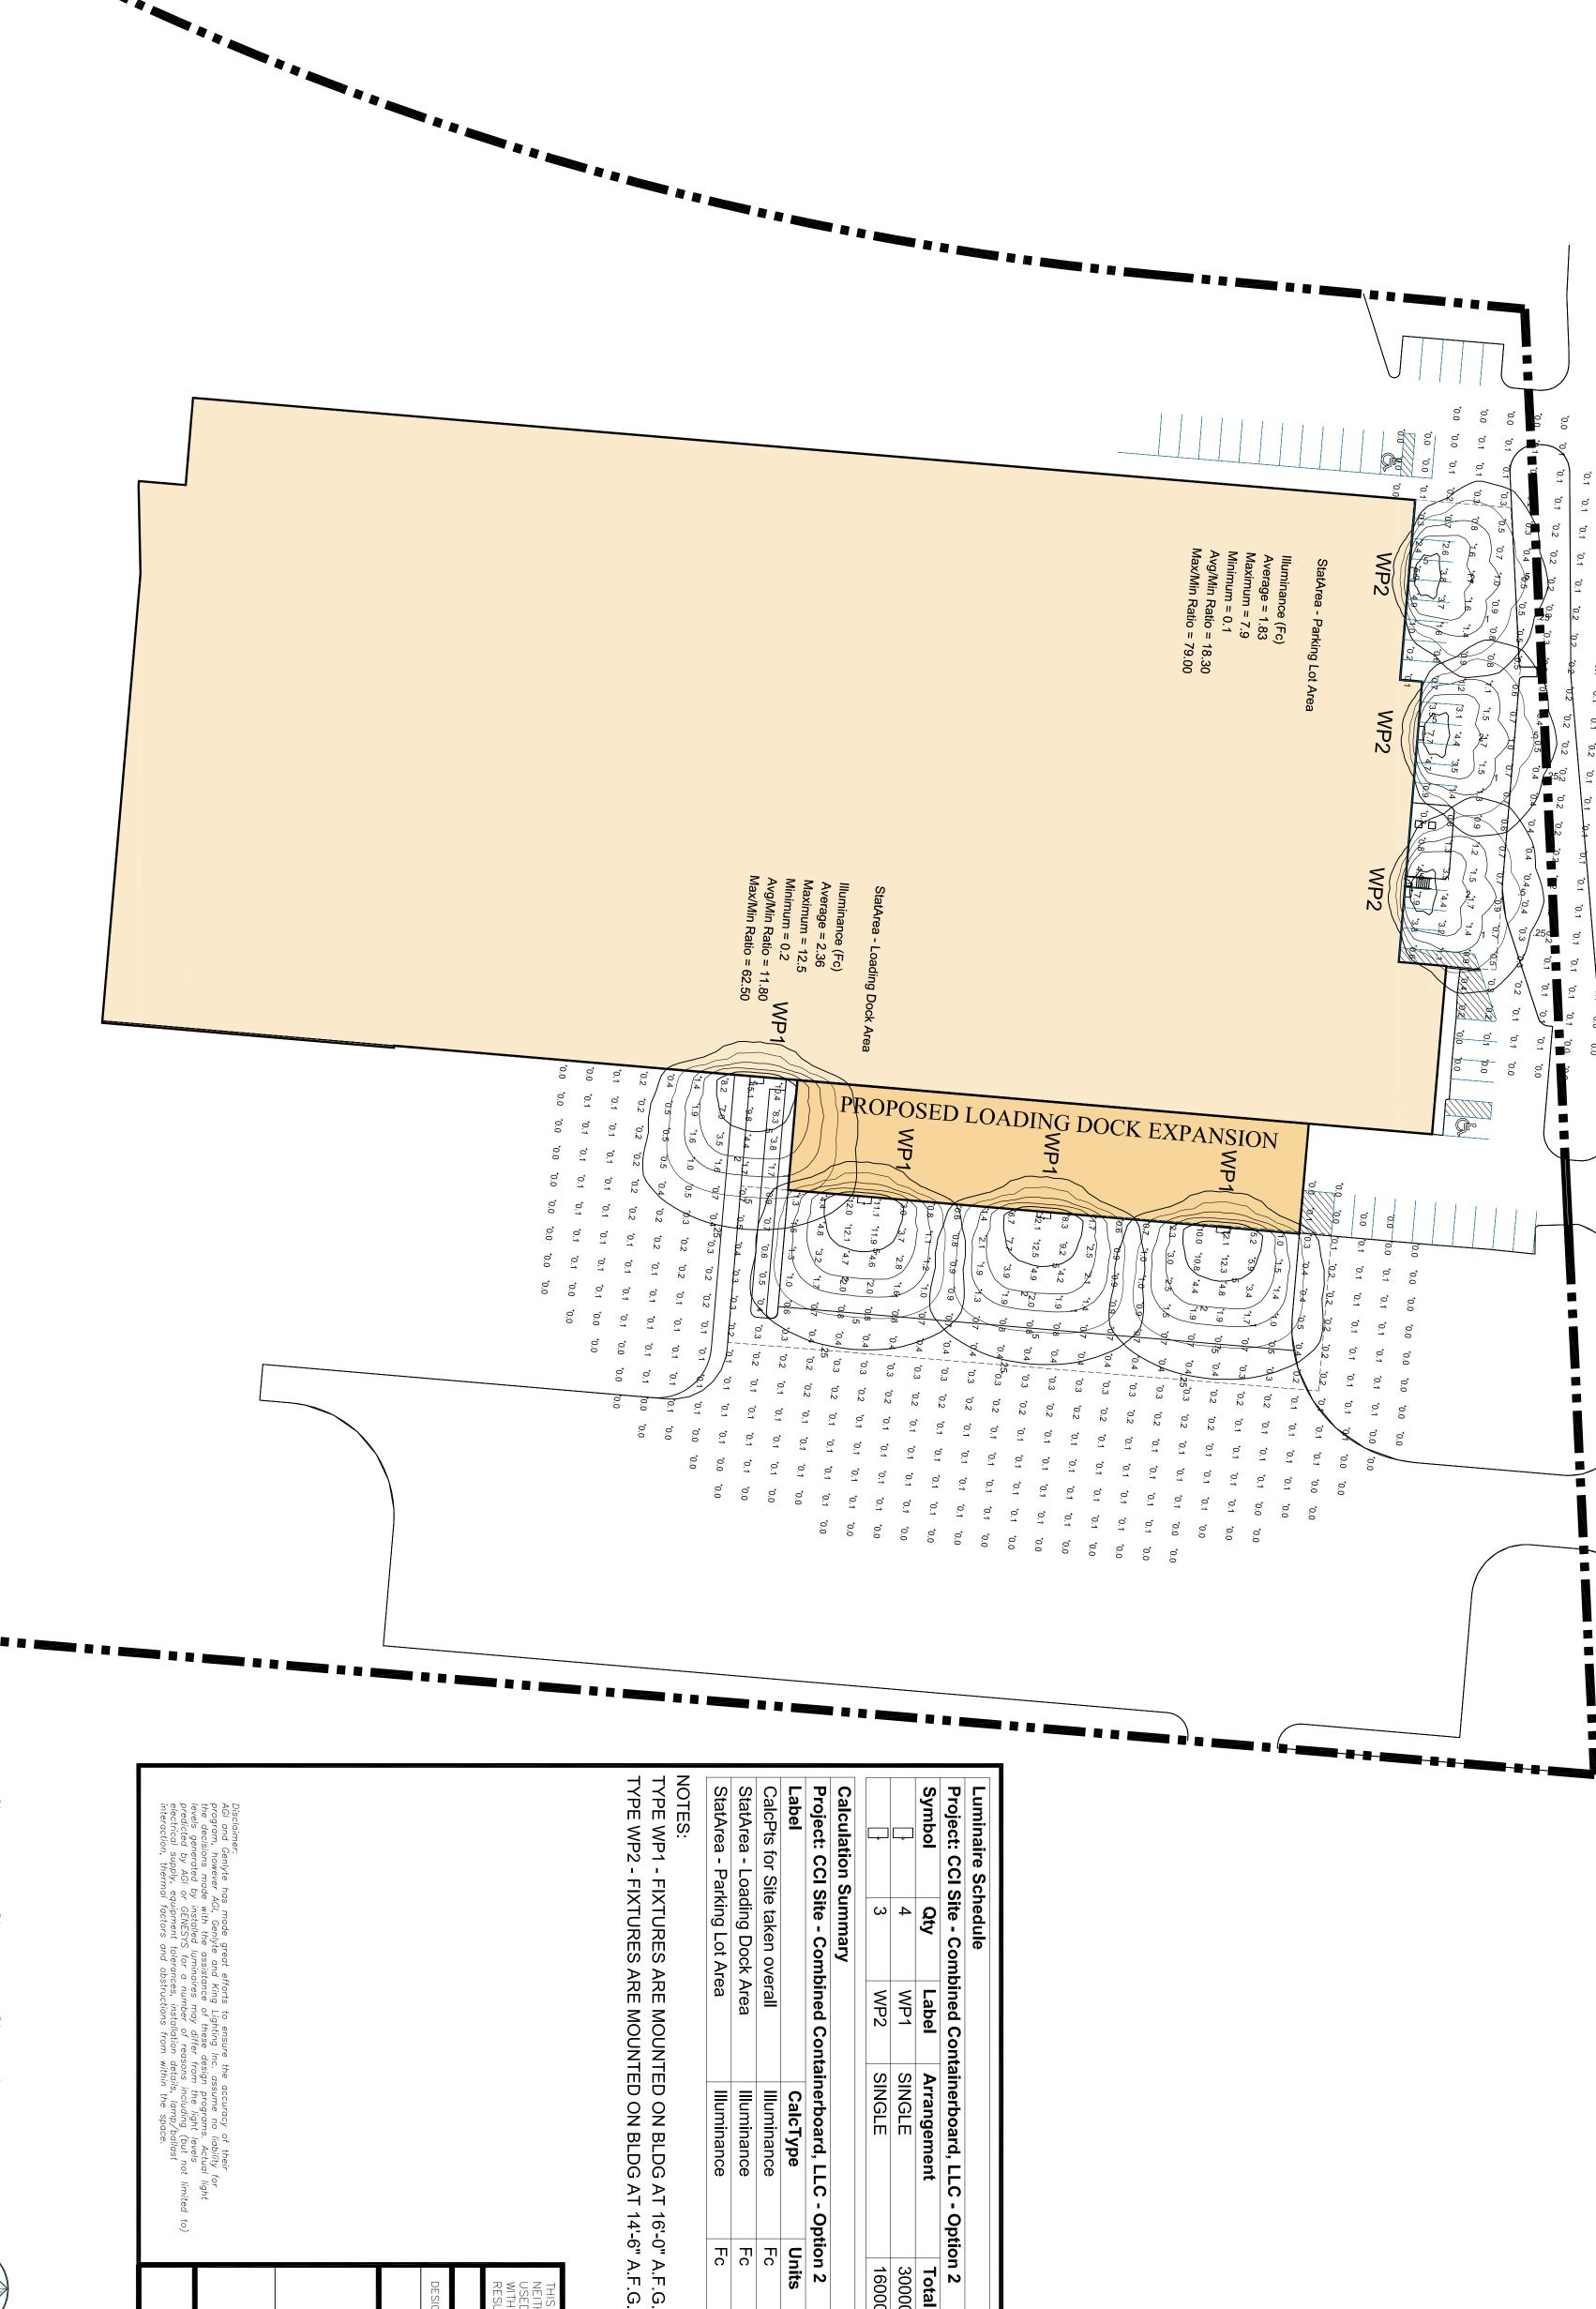



Fc Fc

**Avg**0.48
2.36
1.83

Max 15.1 12.5 7.9

0.0 Min 0.1

Avg/Min N.A. 11.80 18.30

62.50 79.00

Max/Min N.A.

Total Lamp Lumens LLF
30000 0.850

Description
Lithonia TWH 250S VOLTS FINISH LPI
Lithonia TWH 150S VOLTS FINISH LPI

SITE I LIGHTIN GPL



LIGHTING SITE PLAN

SCALE 1"=40'-0"

SIGNER


CHECKED

DATE 06/14/11

CCI Site

Lighting Calculations for - Combined Containerboard, LLC

King Lighting, Inc.
515 Madison Avenue, Suite 300
Covington, Kentucky 41011
(859) 261-5511 Fax (859) 261-2228
www.king-lighting.com

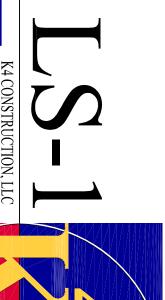

THIS DOCUMENT, AND THE IDEAS AND DESIGNS INCORPORATED HEREIN, IS THE PROPERTY OF K4 ARCHITECTURE, L.L.C. AND IS NOT TO BE USED, IN WHOLE OR IN PART, FOR ANY OTHER PROJECT, WITHOUT THE WRITTEN AUTHORIZATION OF K4 ARCHITECTURE, L.L.C. COPYRIGHT 2002: K4 ARCHITECTURE, L.L.C. ALL RIGHTS RESERVED